


THE INFORMATION CONTAINED IN THIS DRAWING IS THE SOLE PROPERTY OF L-COM, INC. ANY REPRODUCTIONS IN PART OR WHOLE WITHOUT THE WRITTEN PERMISSION OF L-COM, INC. IS PROHIBITED.

REVISIONS			
REV	DESCRIPTION	DATE	APPROVED
A	RELEASED FOR PRODUCTION	4/27/01	D. PARHAM
B	ECN2004: CORRECTED CONN GENDER IN TABLE & CHANGED L-COM CABLE P/N.	3/14/05	D. PARHAM
C	ECN#2228: ADDED NOTES AND "2 CONDUCTORS" TO CABLE DESCRIPTION	10/11/05	D. PARHAM

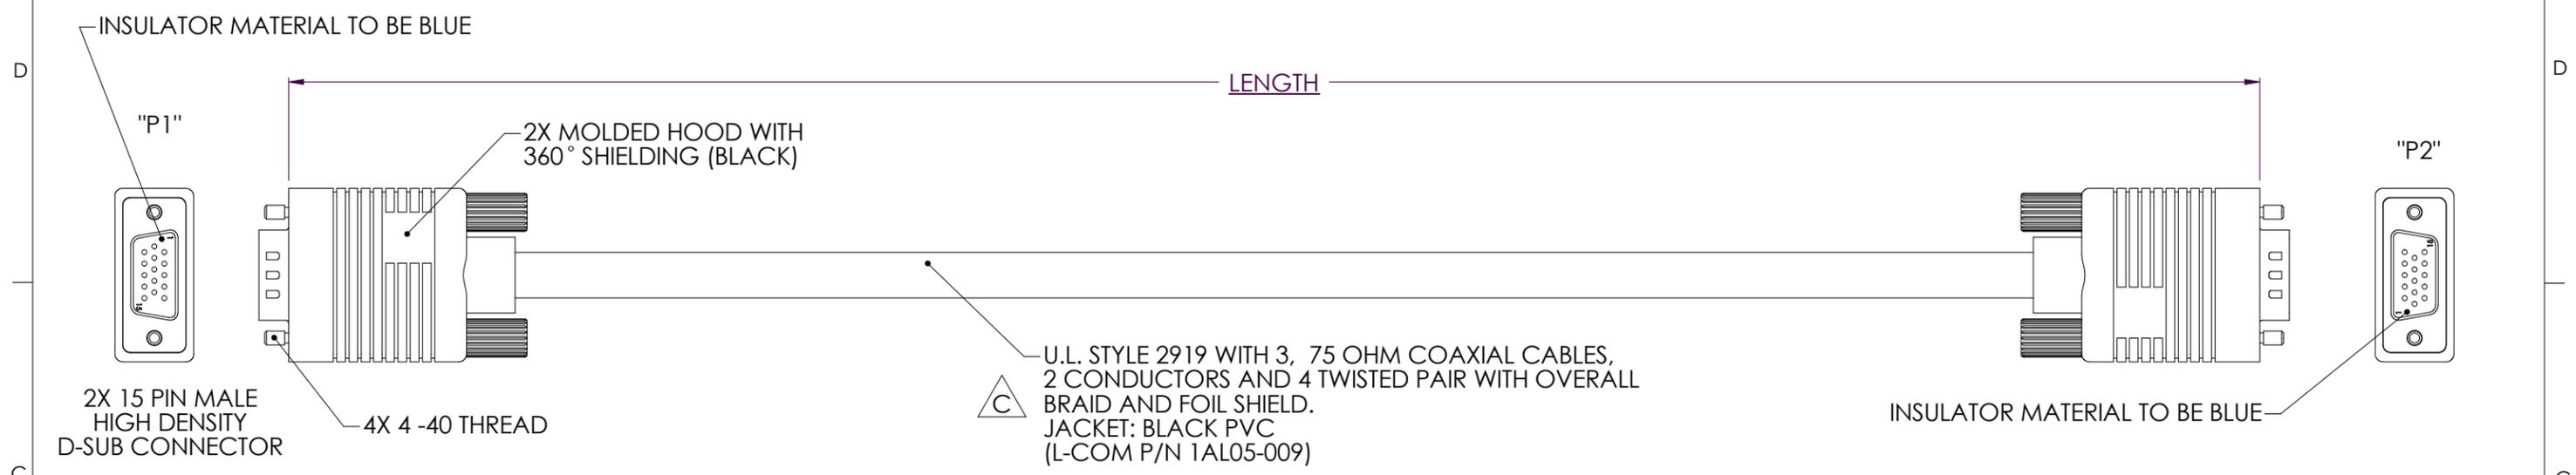

MODEL	LENGTH	
	FEET	METERS
CTL3VGAMM-3B	3.0	0.91
CTL3VGAMM-5B	5.0	1.52
CTL3VGAMM-10B	10.0	3.05
CTL3VGAMM-20B	20.0	6.09
CTL3VGAMM-25B	25.0	7.62
CTL3VGAMM-50B	50.0	15.24
CTL3VGAMM-100B	100.0	30.48
CTL3VGAMM-150B	150.0	45.72
CTL3VGAMM-200B	200.0	60.96

"P1"	FUNCTION	"P2"	PAIR ASSIGNMENT
1	RED SIGNAL	1	
2	GREEN SIGNAL	2	
3	BLUE SIGNAL	3	
4	ID BIT 2	4	PAIR 1
5	GROUND	5	
6	RED SHIELD	6	
7	GREEN SHIELD	7	
8	BLUE SHIELD	8	
9	DDC +5V	9	
10	SYNC RETURN	10	
11	ID BIT 0	11	PAIR 2
12	BIDIRECTIONAL DATA	12	
13	HORIZONTAL SYNC	13	
14	VERTICAL SYNC	14	PAIR 3 (WITH PIN 10)
15	ID BIT 3, DATA CLOCK	15	PAIR 4 (WITH PIN 10)
SHELL	BRAIDED SHIELD OR DRAIN WIRE	SHELL	

- NOTES:**
- 1.0 ELECTRICAL:**
 1.1 UNLESS OTHERWISE SPECIFIED, WIRING IS STRAIGHT THROUGH FROM PIN TO PIN.
 1.2 EACH CABLE ASSEMBLY SHALL BE SUBJECTED TO AND PASS A CONTINUITY TEST.
- 2.0 PACKAGING:**
 2.1 THE PRODUCT SHALL BE PRESERVED & PACKAGED IN A MANNER WHICH WILL AFFORD ADEQUATE PROTECTION AGAINST CORROSION, DETERIORATION, AND PHYSICAL DAMAGE DURING SHIPMENT.
 2.2 INDIVIDUALLY PACKAGE EACH ASSEMBLY UTILIZING APPROPRIATE SIZED BAG DEPICTED ON 1AN01-001-OD1. MARK EACH BAG PER LSP-010-1.
- 3.0 WORKMANSHIP**
 3.1 CABLE ASSEMBLIES SHALL BE MANUFACTURED IN SUCH A MANNER AS TO BE UNIFORM IN QUALITY AND SHALL BE FREE FROM BURRS, CRAZING, CRACKS, VOIDS, PIMPLES, CHIPS, BLISTERS, PINHOLES, SHARP CUTTING EDGES, AND OTHER DEFECTS THAT WILL ADVERSELY AFFECT LIFE, SERVICEABILITY, OR APPEARANCE.
- 4.0 VISUAL AND MECHANICAL**
 4.1 CABLE ASSEMBLIES SHALL BE INSPECTED TO VERIFY COMPLIANCE TO THIS DRAWING.

UNLESS OTHERWISE SPECIFIED DIMENSIONS ARE IN INCHES
 TOLERANCES ARE:
 .X ±.1
 .XX ±.05
 .XXX ±.005
 CABLE LENGTH TOLERANCE
 ≤300" ±5% >300" ±2%

APPROVALS	DATE
DRAWN BY D PARHAM	4/23/2001
CHECKED BY T CLARK	4/23/2001
APPROVED BY R CARRICK	4/27/2001

L-com 45 BEECHWOOD DRIVE
 CONNECTIVITY PRODUCTS NORTH ANDOVER, MA 01845

PRODUCT DESCRIPTION
CA SVGA HD15 M/HD15 M BLACK

DRAWING TITLE
OUTLINE DRAWING

SIZE B	FSCM NO. 43321	DWG. NO. CTL3VGAMM-3B-OD1	REV. C
------------------	--------------------------	-------------------------------------	------------------

SCALE: 1:1 CAD FILE: CTL3VGAMM-3B-OD1.SLDDRW SHEET 1 OF 1